



SAN LUIS OBISPO COUNTY
DEPARTMENT OF PUBLIC WORKS

Paavo Ogren, Director

County Government Center, Room 207 • San Luis Obispo CA 93408 • (805) 781-5252

Fax (805) 781-1229

email address: pwd@co.slo.ca.us

June 26, 2012

**FAX ONLY &
ATTACH TO CONTRACT**

**ADDENDUM NO. 3 TO
LOS OSOS WASTEWATER PROJECT
COLLECTION SYSTEM PUMP STATIONS
LOS OSOS, CA
CONTRACT NO. 300448.08.01.PS**

The final day, time and location for submittal of Bid remain unchanged by this addendum:

Date / Time: Thursday, June 28, 2012 at 3:00 p.m.

At: Office of the County Clerk
1055 Monterey Street, Room D-120
San Luis Obispo, California 93408

Certain revisions are hereby incorporated into the Bidding Documents for the subject project. These revisions are as follows:

Division 4, Masonry, is hereby amended as follows:

- 1) On page 04220-7, delete Paragraph 2.01.B.2 in its entirety and insert the following in its place:
2. BLANK

Division 7, Thermal and Moisture Protection, is hereby amended as follows:

 
- 1) On page 07210-2, delete Paragraph 2.02.A.1 in its entirety and insert the following in its place:
 1. Prefomed Units: Sizes to fit applications indicated, selected from manufacturer's standard thickness, widths, and lengths. R value = R19.

Volume 2, Pump Stations Drawings, is hereby amended as follows:

Replace each of the following sheets with the corresponding revised sheet attached to this Addendum No. 3:

PS-S-012 PS-E-102 PS-E-103 PS-E-402

All bidders shall acknowledge acceptance of this correction notice. **PLEASE FAX TO US, TODAY, A SIGNED COPY OF THIS SHEET INDICATING CONFIRMATION OF RECEIPT OF THIS ADDENDUM (FAX (805) 781-1229).** If you are unable to read the fax, please call Cori Marsalek in the Public Works Department at (805) 781-5252.



PAAVO OGREN
Director of Public Works

File: Contract No. 300448.08.01.PS

ACKNOWLEDGMENT


Company Name

Printed Name

Signature

Date

L:\DESIGN\JUN12\300448.08.01.PS Addendum No. 3.doc.jwerst.taw

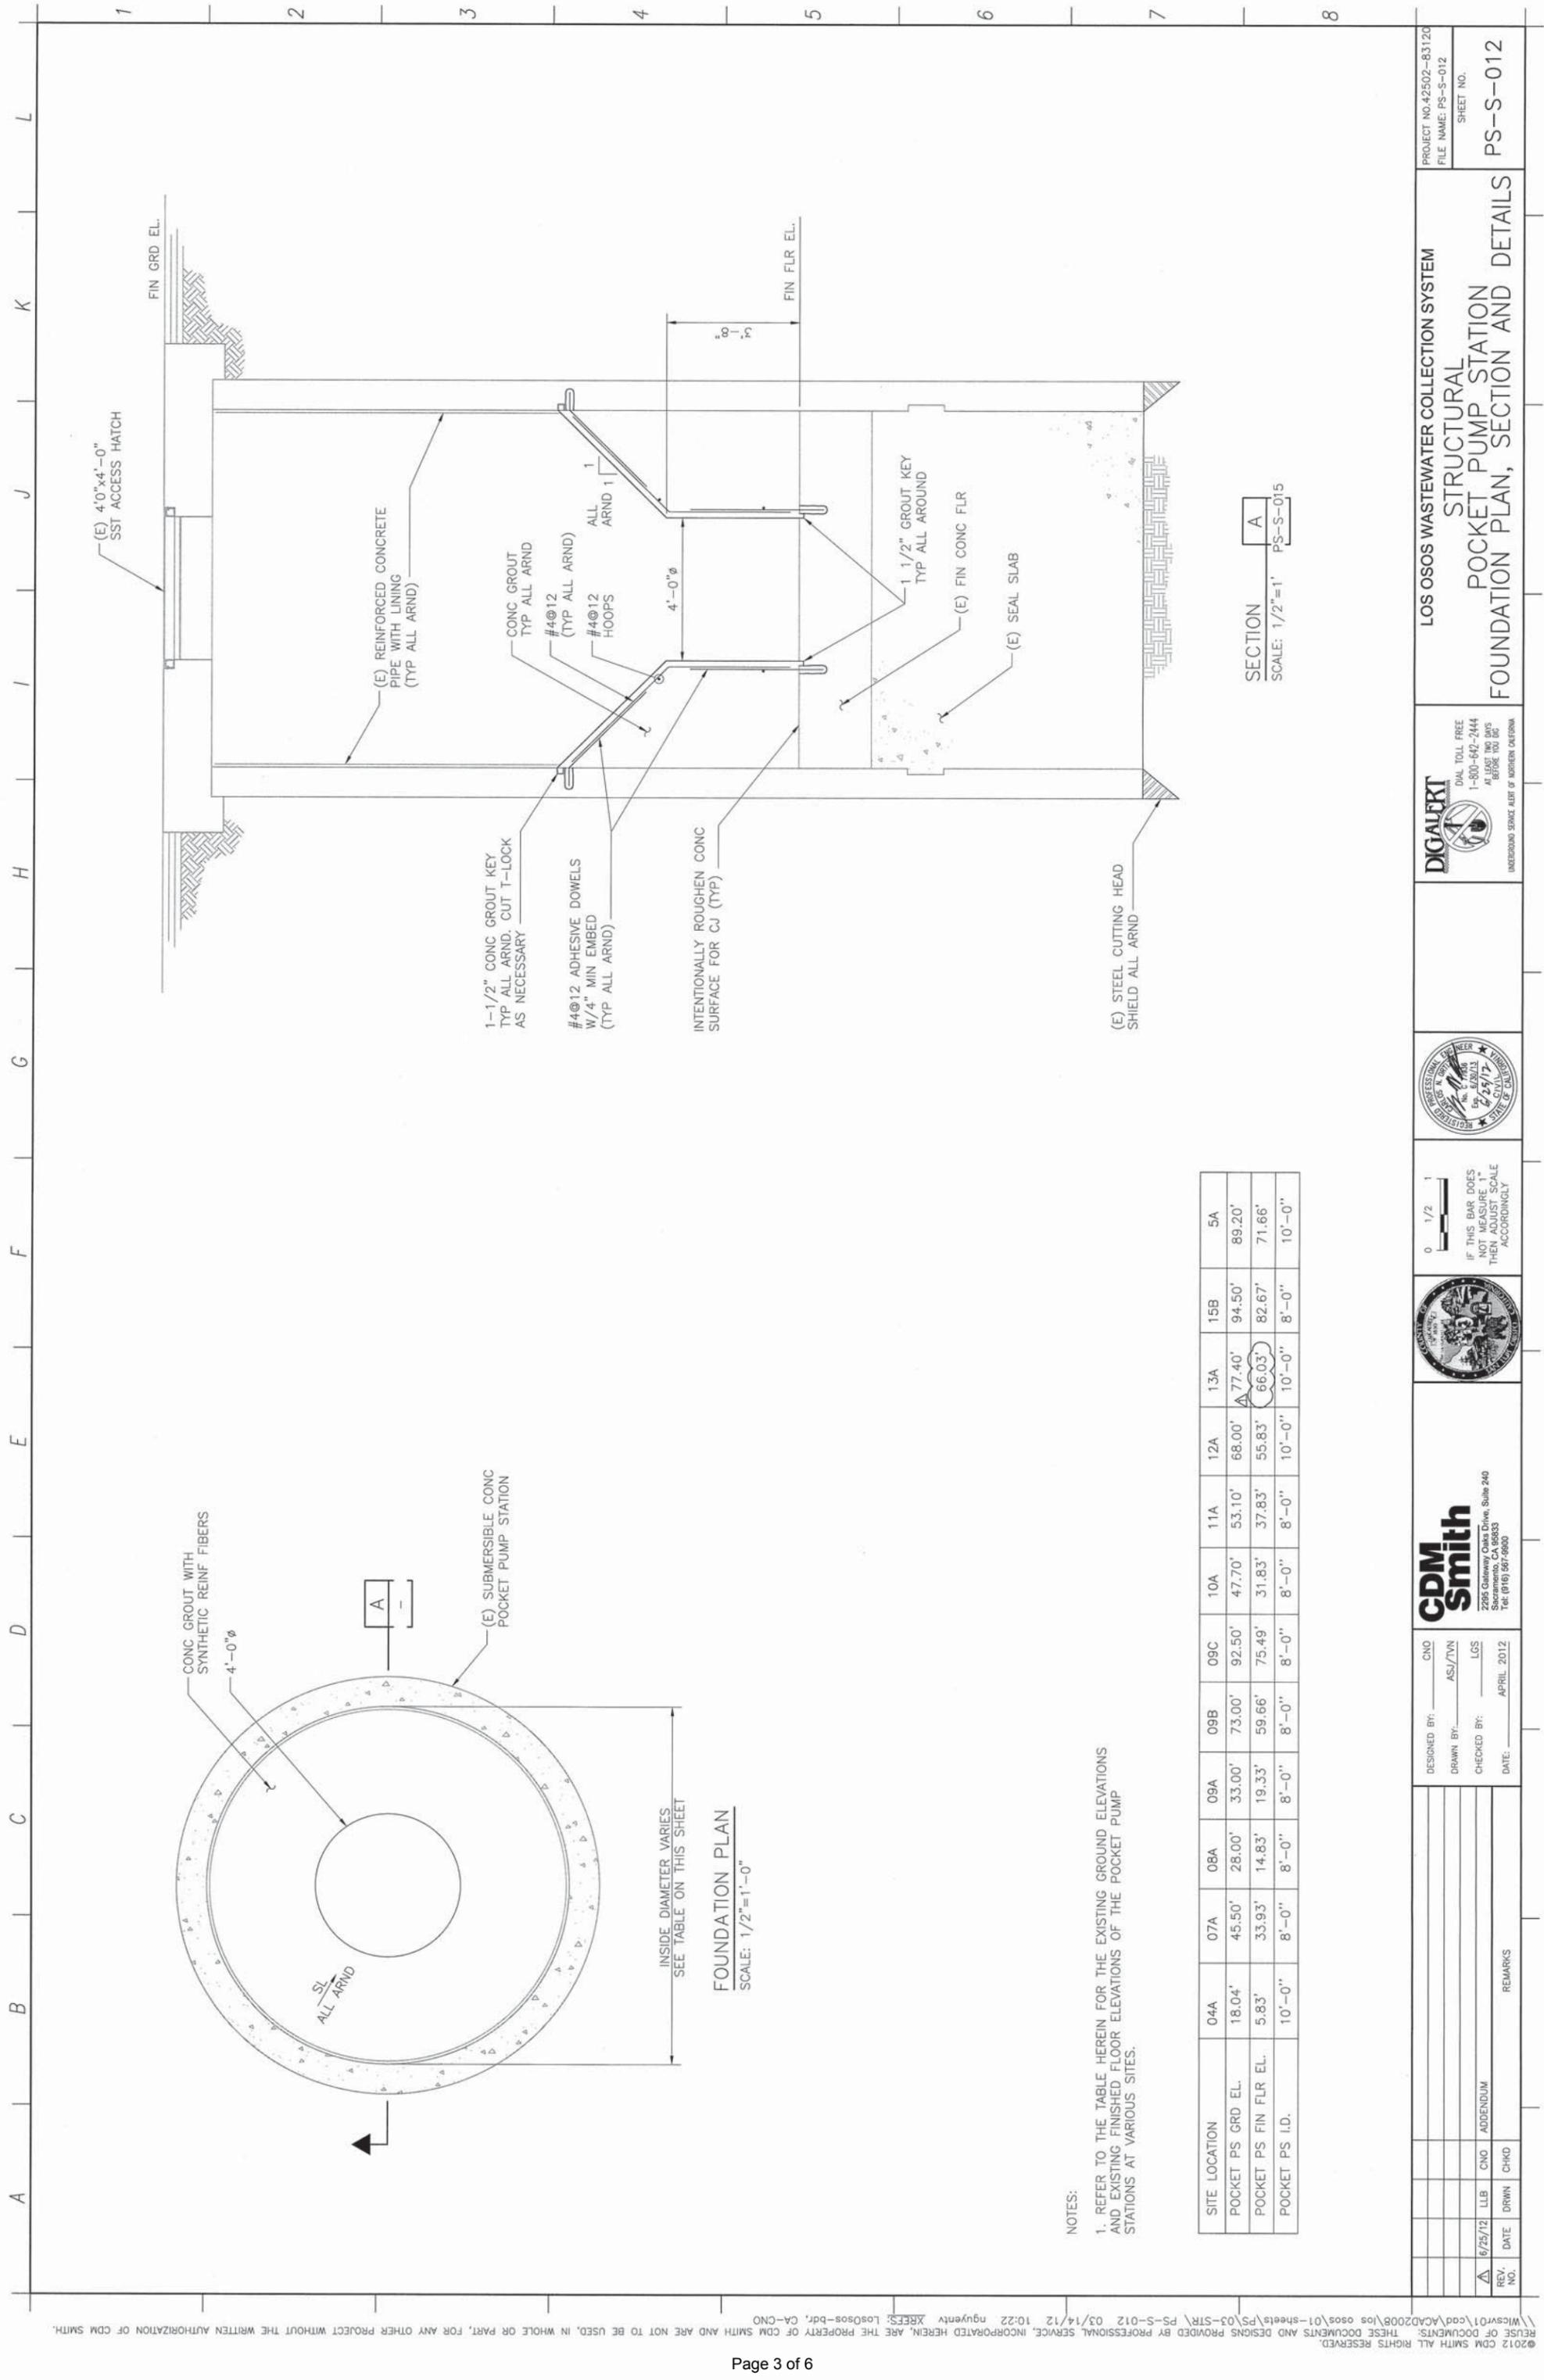

PROJECT NO. 42502-83120
 FILE NAME: PS-S-012
 SHEET NO.
 PS-S-012

LOS OSOS WASTEWATER COLLECTION SYSTEM
 STRUCTURAL
 POCKET PUMP STATION
 FOUNDATION PLAN, SECTION AND DETAILS

SECTION A
 SCALE: 1/2"=1' PS-S-015

PROFESSIONAL SEAL
 REGISTERED PROFESSIONAL ENGINEER
 No. 67853
 DATE: 7/17
 STATE OF CALIFORNIA

DESIGNED BY: CND
 DRAWN BY: ASJ/TVN
 CHECKED BY: LGS
 DATE: APRIL 2012

REVISIONS
 NO. DATE DRWN CHKD REMARKS

2012 CDM SMITH ALL RIGHTS RESERVED.
 THESE DOCUMENTS AND DESIGNS PROVIDED BY PROFESSIONAL SERVICE, INCORPORATED HEREIN, ARE THE PROPERTY OF CDM SMITH AND ARE NOT TO BE USED, IN WHOLE OR PART, FOR ANY OTHER PROJECT WITHOUT THE WRITTEN AUTHORIZATION OF CDM SMITH.

INSIDE DIAMETER VARIES
 SEE TABLE ON THIS SHEET

FOUNDATION PLAN
 SCALE: 1/2"=1'-0"

NOTES:
 1. REFER TO THE TABLE HEREIN FOR THE EXISTING GROUND ELEVATIONS AND EXISTING FINISHED FLOOR ELEVATIONS OF THE POCKET PUMP STATIONS AT VARIOUS SITES.

SITE LOCATION	04A	07A	08A	09A	09B	09C	10A	11A	12A	13A	15B	5A
POCKET PS GRD EL.	18.04'	45.50'	28.00'	33.00'	73.00'	92.50'	47.70'	53.10'	68.00'	77.40'	94.50'	89.20'
POCKET PS FIN FLR EL.	5.83'	33.93'	14.83'	19.33'	59.66'	75.49'	31.83'	37.83'	55.83'	66.03'	82.67'	71.66'
POCKET PS I.D.	10'-0"	8'-0"	8'-0"	8'-0"	8'-0"	8'-0"	8'-0"	8'-0"	10'-0"	10'-0"	8'-0"	10'-0"

IF THIS BAR DOES NOT MEASURE 1" THEN ADJUST SCALE ACCORDINGLY

CDM Smith
 2205 Gateway Oaks Drive, Suite 240
 Sacramento, CA 95833
 Tel: (916) 587-9900


DIAL TOLL FREE
 1-800-642-2444
 AT THE TIME OF THIS OFFER
 UNDERGROUND SERVICE ALERT OF NORTHERN CALIFORNIA

PROFESSIONAL SEAL
 REGISTERED PROFESSIONAL ENGINEER
 No. 67853
 DATE: 7/17
 STATE OF CALIFORNIA

DESIGNED BY: CND
 DRAWN BY: ASJ/TVN
 CHECKED BY: LGS
 DATE: APRIL 2012

REVISIONS
 NO. DATE DRWN CHKD REMARKS

2012 CDM SMITH ALL RIGHTS RESERVED.
 THESE DOCUMENTS AND DESIGNS PROVIDED BY PROFESSIONAL SERVICE, INCORPORATED HEREIN, ARE THE PROPERTY OF CDM SMITH AND ARE NOT TO BE USED, IN WHOLE OR PART, FOR ANY OTHER PROJECT WITHOUT THE WRITTEN AUTHORIZATION OF CDM SMITH.

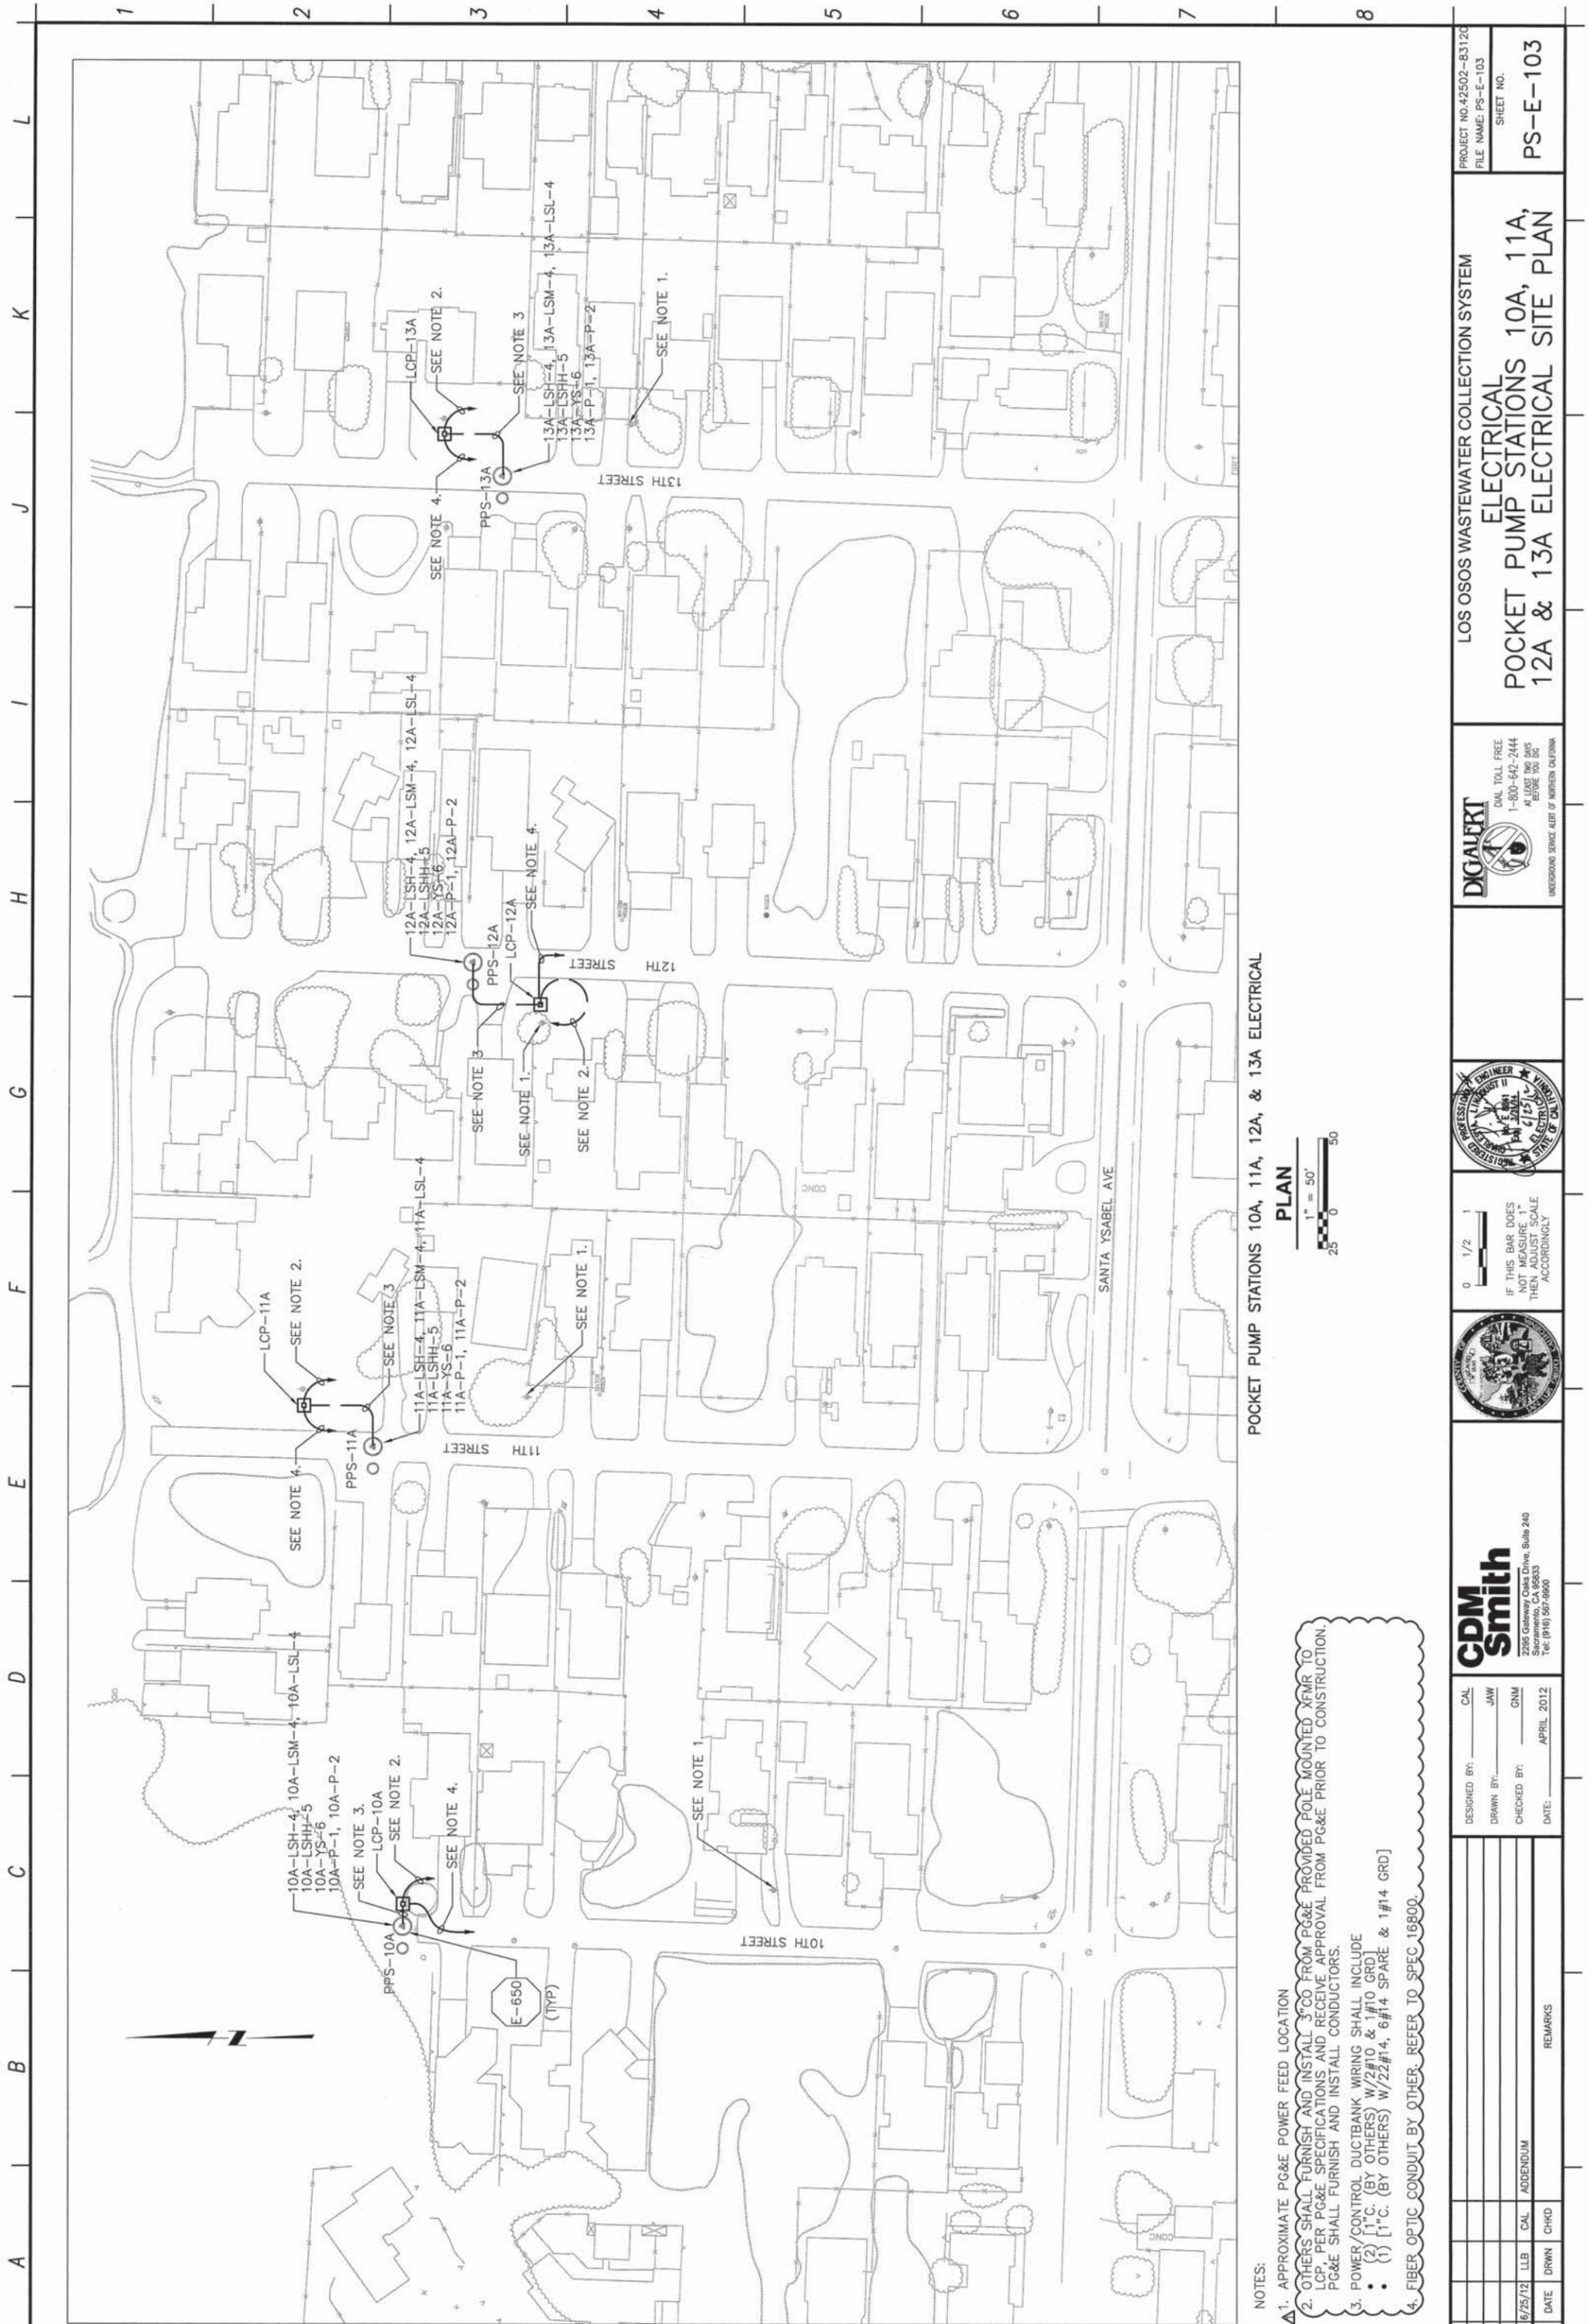

POCKET PUMP STATIONS 10A, 11A, 12A, & 13A ELECTRICAL

- NOTES:
1. APPROXIMATE PG&E POWER FEED LOCATION
 2. OTHERS SHALL FURNISH AND INSTALL 3" CO FROM PG&E PROVIDED POLE MOUNTED XMR TO LCP PER PG&E SPECIFICATIONS AND RECEIVE APPROVAL FROM PG&E PRIOR TO CONSTRUCTION. PG&E SHALL FURNISH AND INSTALL CONDUCTORS.
 3. POWER/CONTROL DUCTBANK WIRING SHALL INCLUDE
 - (2) [1" C. (BY OTHERS) W/2#10 & 1#10 GRD]
 - (1) [1" C. (BY OTHERS) W/2#14, 6#14 SPARE & 1#14 GRD]
 4. FIBER OPTIC CONDUIT BY OTHER. REFER TO SPEC 16800.

<p>CDM Smith 2208 Gateway Oaks Drive, Suite 240 Sacramento, CA 95833 Tel: (916) 987-9900</p>							
DESIGNED BY:	CALL	JAW	GNM	APRIL 2012			
DRAWN BY:	JAW	GNM					
CHECKED BY:							
DATE:							
REV. NO.	6/25/12	LLB	CALL	APPENDIX	REMARKS		
	DATE	DRWN	CHKD				
PROJECT NO: 42502-83120 FILE NAME: PS-E-103 SHEET NO: PS-E-103							



- NOTES:
- APPROXIMATE PG&E POWER FEED LOCATION
 - OTHERS SHALL FURNISH AND INSTALL 3" CO FROM PG&E PROVIDED POLE MOUNTED XFMR TO LCP, PER PG&E SPECIFICATIONS AND RECEIVE APPROVAL FROM PG&E PRIOR TO CONSTRUCTION. PG&E SHALL FURNISH AND INSTALL CONDUCTORS.
 - (2) 1" C. (BY OTHERS) W/2#10 & 1#10 GRD
 - (1) 1" C. (BY OTHERS) W/2#14, 6#14 SPARE & 1#14 GRD
 - POWER/CONTROL DUCTBANK WIRING SHALL INCLUDE
 - (2) 1" C. (BY OTHERS) W/2#10 & 1#10 GRD
 - (1) 1" C. (BY OTHERS) W/2#14, 6#14 SPARE & 1#14 GRD
 - FIBER OPTIC CONDUIT BY OTHER. REFER TO SPEC 16800.

PROJECT NO. 42502-8312C FILE NAME: PS-E-402	
SHEET NO. PS-E-402	
LOS OSOS WASTEWATER COLLECTION SYSTEM ELECTRICAL POCKET PUMP STATIONS 09B, 09C & 15B ELECTRICAL SITE PLAN	
	DIAL TOLL FREE 1-800-642-2444 AT LEAST TWO DAYS BEFORE YOU DIG UNDERGROUND SERVICE ALERT OF NORTHERN CALIFORNIA
	0 1/2 1 IF THIS BAR DOES NOT MEASURE 1" THEN ADJUST SCALE ACCORDINGLY
	DESIGNED BY: CAL DRAWN BY: JAW CHECKED BY: GNM DATE: APRIL 2012
2295 Gateway Oaks Drive, Suite 240 Sacramento, CA 95833 Tel: (916) 567-9660	REMARKS REV. NO. DATE DRWN CHKD 6/25/12 LLB CAL ADDENDUM